


VICINITY MAP

LOCATE HYDRANT SO THAT
DRIVE IS NOT BLOCKED
WHEN CONNECTED.
CONNECTION IS ON THE SIDE
OF THE TRUCK

PROVIDE PROJECT NAME
PROJECT ADDRESS, CITY,
APPLICANT NAME
APPLICANT PHONE
PERMIT NO.

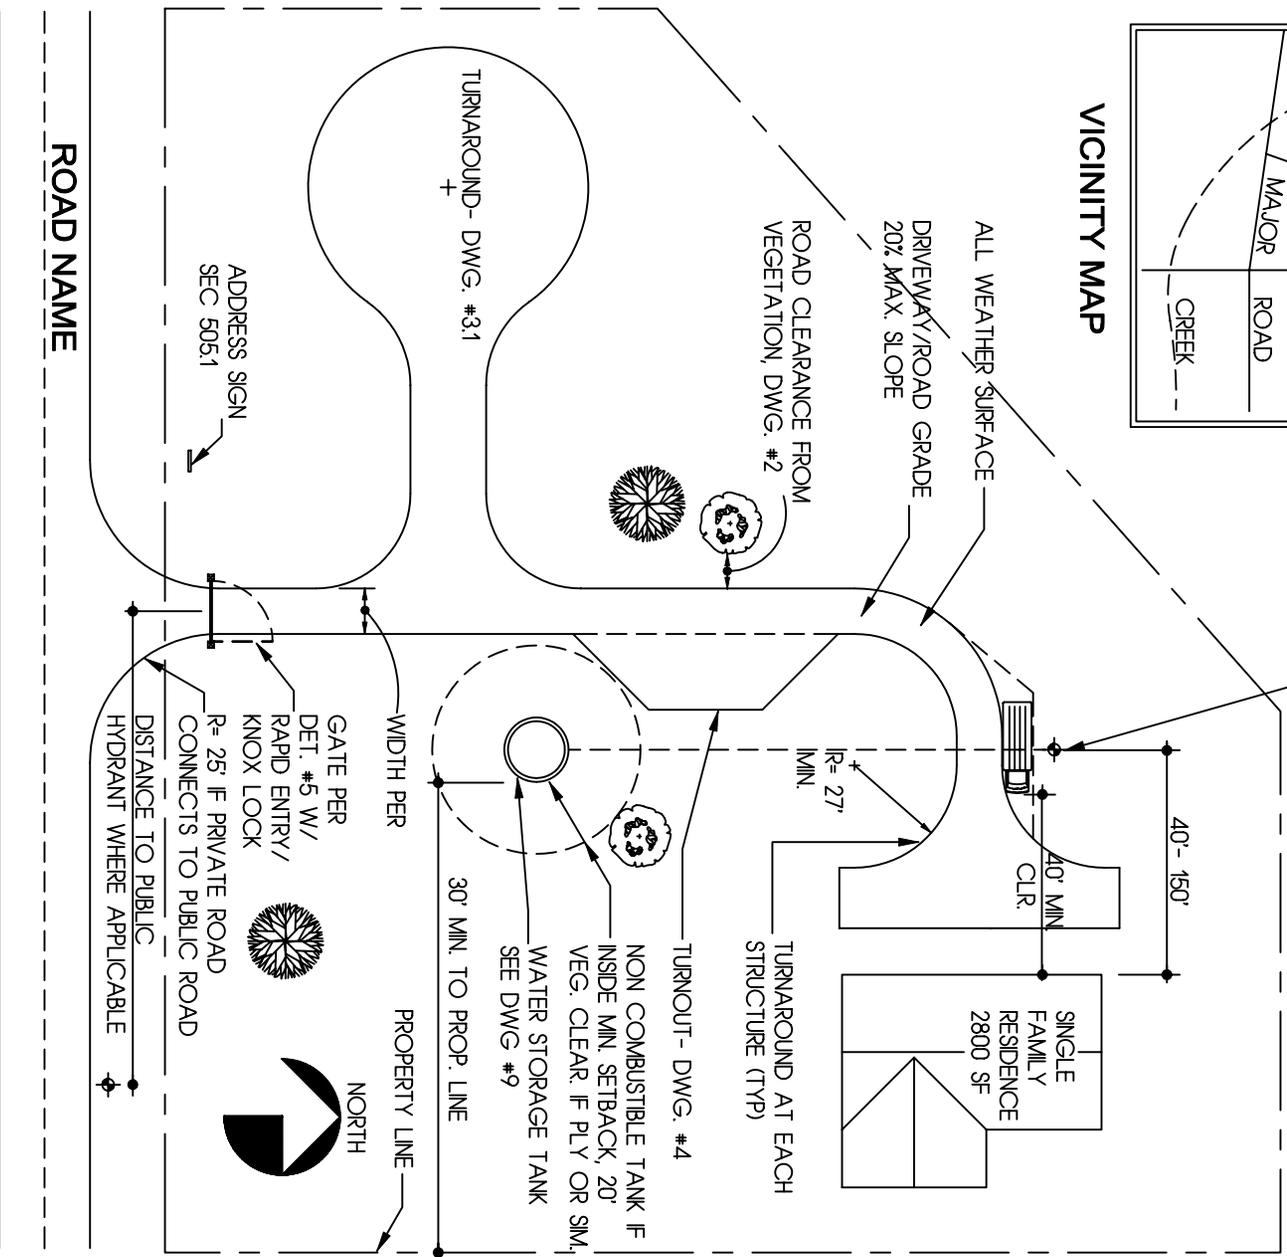

ROAD NAME

RESIDENTIAL SAMPLE SITE PLAN

FIRE SAFE STANDARDS

ST. HELENA FIRE DEPARTMENT

1480 MAIN STREET
ST. HELENA, CALIFORNIA 94574
FIRE DEPT. TELEPHONE (707) 967-2880 FAX (707) 963-7057
CITY HALL TELEPHONE (707) 967-2792 FAX (707) 963-7748

1/50" = 1'-0"	1
SCALE	
REVISION DATE MAY 15, 2009	

DRAWING NO. 1